

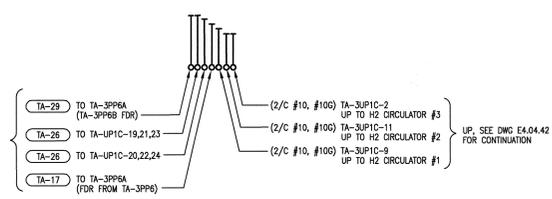


H G F E D C A

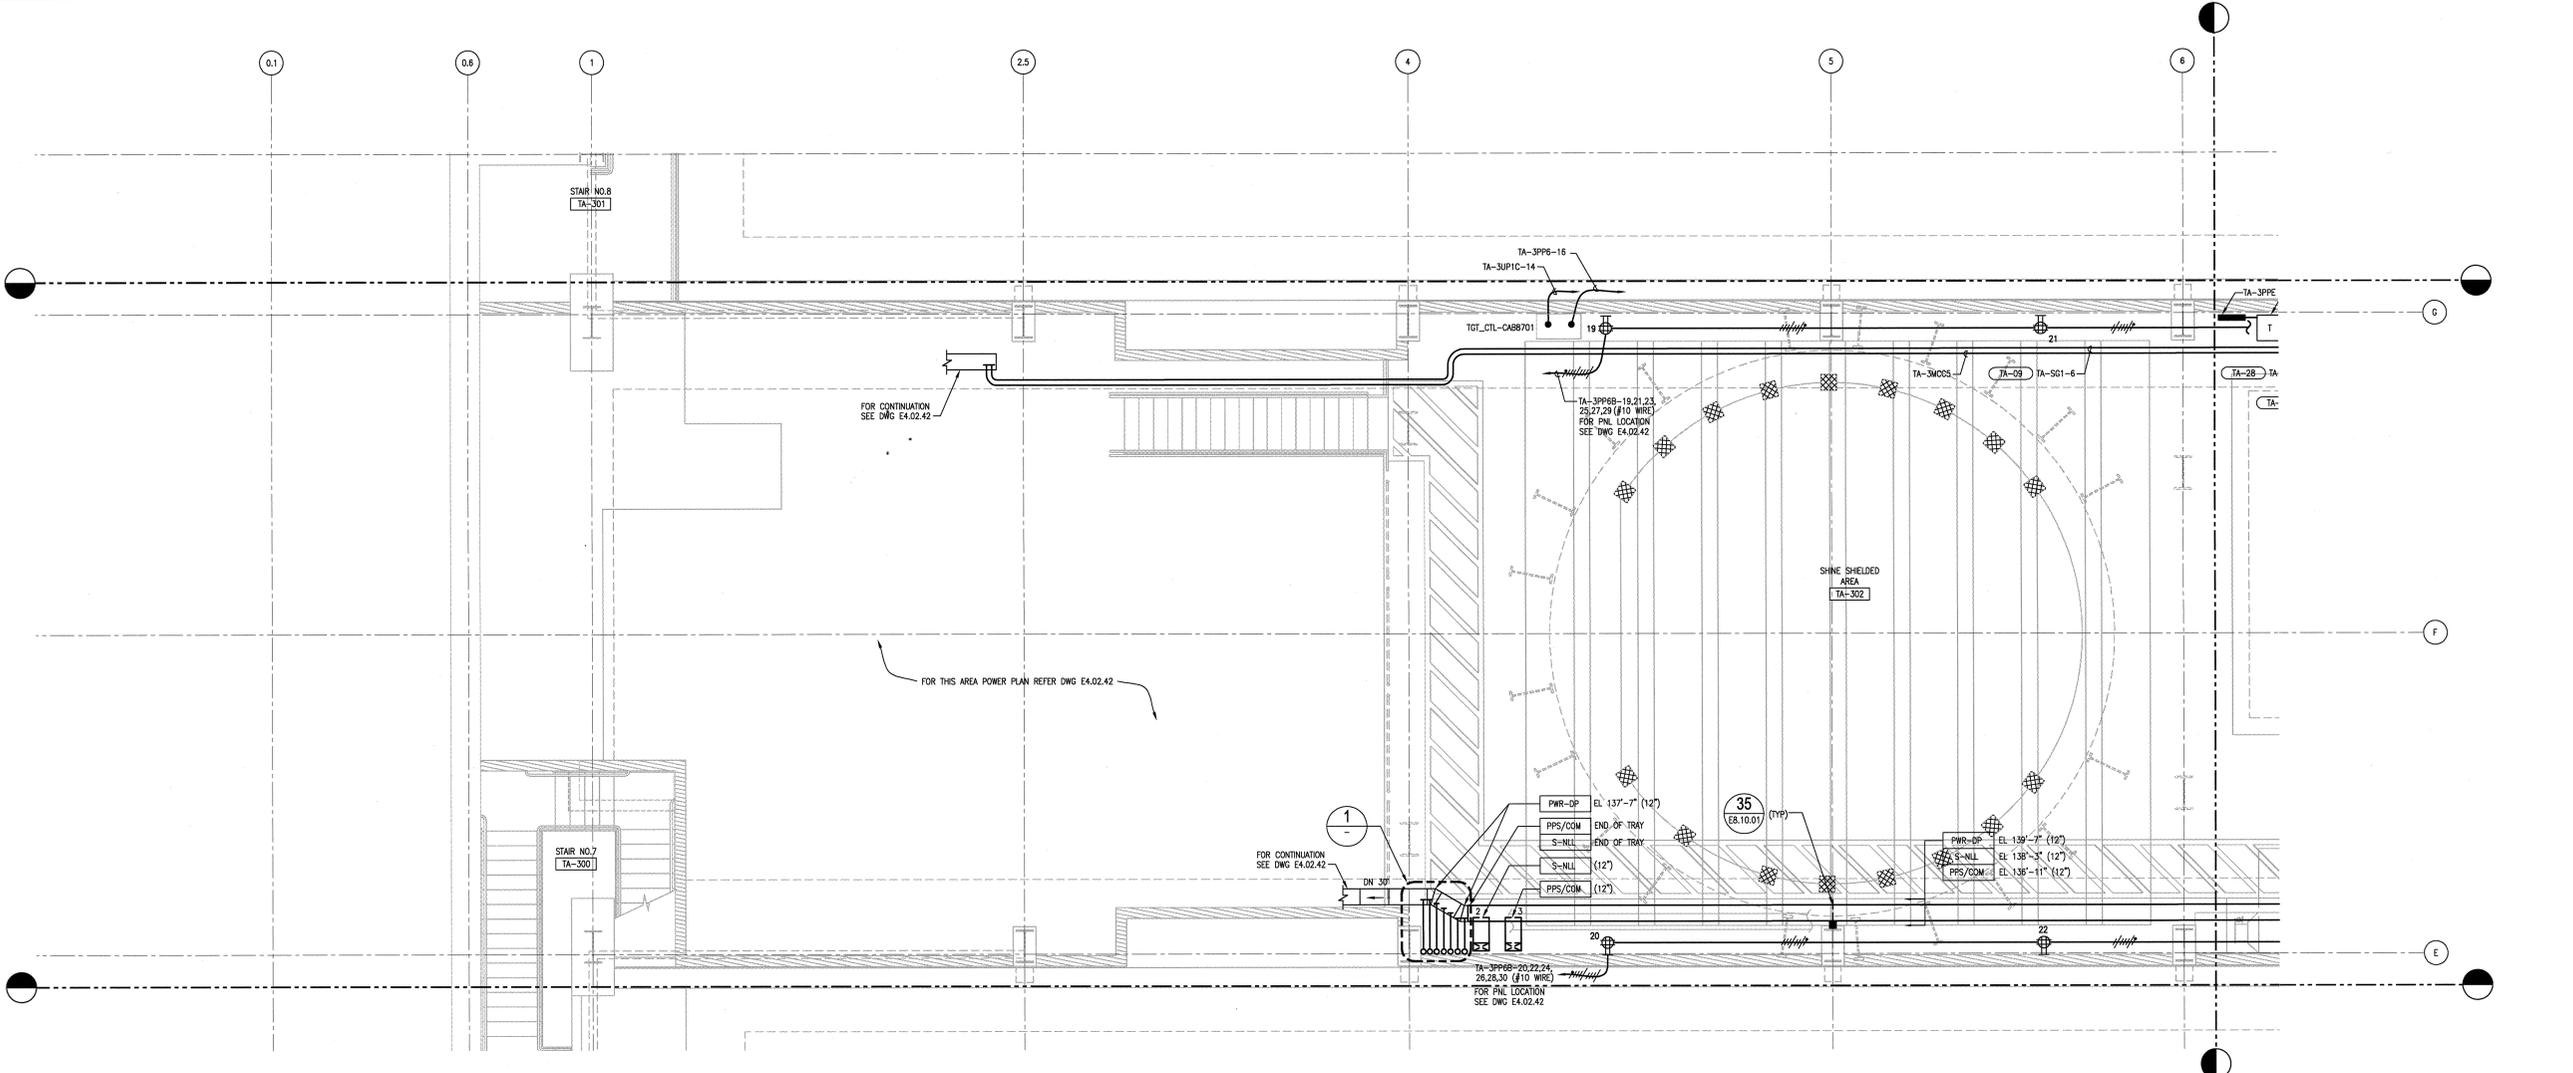

1 DETAIL SCALE: 1/4"=1'-0"

- GENERAL NOTES: 1. SEE DWG E8.10.30, E8.10.31, E8.10.32 & E8.10.33 FOR MCC SCHEDULES... 2. CONDUIT ADJACENT OR CONDUIT TO CABLE TRAY... 3. ALL TRAYS ARE LADDER TYPE... 4. SEE DWG H9.10.30 & H9.30.31 FOR HVAC SCHEDULES... 5. TA-XX SYMBOL DENOTES FEEDER TAG NO... 6. TA-XX SYMBOL DENOTES WALL AND FLOOR PENETRATION... 7. TA-XX SYMBOL DENOTES CONDUIT/CABLE TRAY SUPPORT...

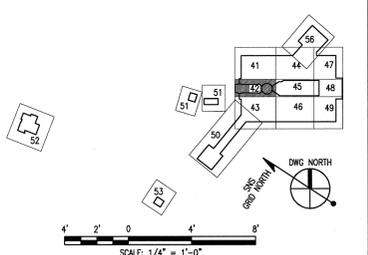

SCALE: 1/4" = 1'-0"

108030700-E8E-8700-A064
Knight Jacobs
Knight Jacobs Joint Venture
701 Scarbora Road, MS 8253
Oak Ridge, TN 37830
865-241-9433
Fax 865-241-3400
Oak Ridge National Laboratory
managed for the DEPARTMENT OF ENERGY under
U.S. GOVERNMENT contract DE-AC05-00OR22725
UT-BATTELLE
PROJECT NAME: SPALLATION NEUTRON SOURCE
TARGET BUILDING ELECTRICAL POWER PLAN LEVEL 3, SECTOR 42
1 48 49 50 PLANT 8 BLDG 8700 FL 1 SH 1 OF TYPE CLASS
3 E X X 8 8700 WBS 1.8.3.7 E4.03.42 0
REV NC NA 53

Table with columns for revision, description, date, and drawing approvals. Includes a revision history table and a drawing approvals table.

NO REPRESENTATION OR WARRANTY... THIS DOCUMENT CONTROLLED BY CHANGE CONTROL SYSTEM 3 ENGINEERING PROCEDURE SNS-ENG-0001 SECTION AND DETAIL KEY