
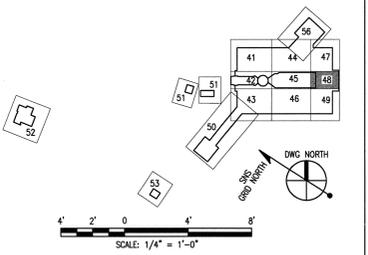


- GENERAL NOTES:**
1. SYMBOL DENOTES CABLE TRAY/CONDUIT SUPPORT FROM WALL/CEILING. REFER TO DWG E8.10.01 FOR TYPICAL DETAILS.
  2. FOR WALL AND FLOOR PENETRATIONS REFER TO CORRESPONDING FLOOR & SECTION POWER PLANS (E4 SERIES) WORK.
  3. SEE POWER PLANS (E4 SERIES) FOR COMPOSITE OF TRAYS FOR ALL SERVICES.
  4. ALL TRAYS SHALL BE LADDER TYPE FOR VERTICAL TRAY RISERS. VENTILATED COVERS SHALL BE PROVIDED.

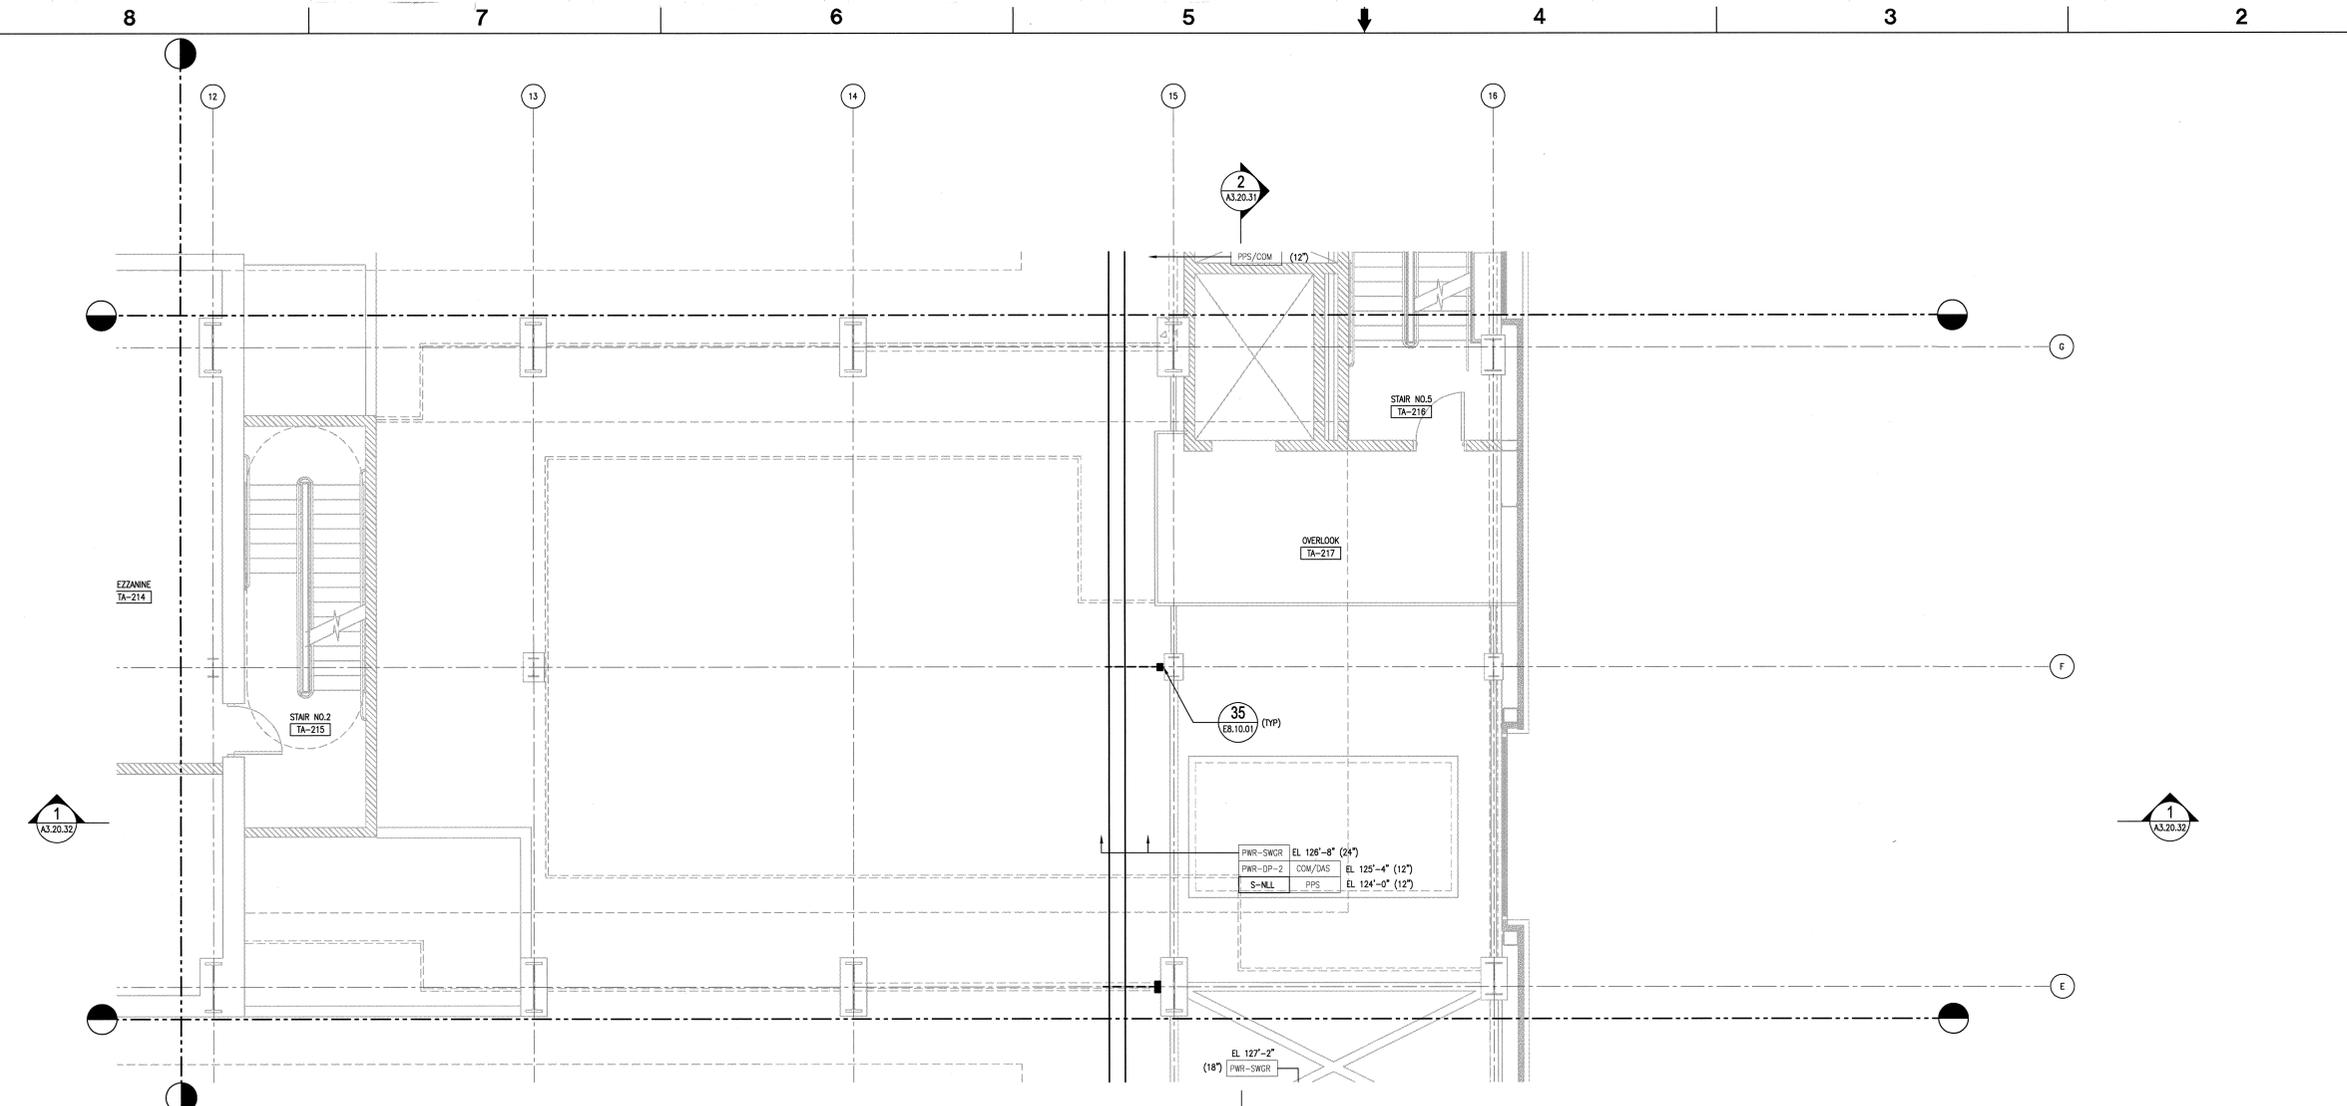

108030700-E8E-8700-A095

**KNIGHT**  
Knight Advanced Technology  
100 West Memphis Drive  
Chattanooga, TN 37405

**UT-BATTELLE**  
Oak Ridge National Laboratory  
managed for the DEPARTMENT OF ENERGY under  
U.S. GOVERNMENT CONTRACT DE-AC05-00OR22725  
UT-BATTELLE, LLC, a UT-Battelle, Tennessee

PROJECT NAME:	SPALLATION NEUTRON SOURCE	
DRAWING TITLE:	TARGET BUILDING ELECTRICAL AUXILIARY PLAN LEVEL 2, SECTOR 48	
REV.	DATE	BY
1	4/18/01	WJS
2	10/26/01	WJS
3	11/2/01	WJS
4		
5		
6		
100		

NO REPRESENTATION OR WARRANTY, EXPRESSED OR IMPLIED, IS MADE AS TO THE ACCURACY, COMPLETENESS OR USEFULNESS OF THE INFORMATION OR STATEMENTS CONTAINED IN THESE DRAWINGS. THE USER OF THESE DRAWINGS SHALL BE RESPONSIBLE FOR OBTAINING ALL NECESSARY PERMITS AND FOR OBTAINING ALL NECESSARY INFORMATION FROM THE RECORD DRAWINGS AND FIELD SURVEY DATA. THE USER SHALL BE RESPONSIBLE FOR OBTAINING ALL NECESSARY INFORMATION FROM THE RECORD DRAWINGS AND FIELD SURVEY DATA. THE USER SHALL BE RESPONSIBLE FOR OBTAINING ALL NECESSARY INFORMATION FROM THE RECORD DRAWINGS AND FIELD SURVEY DATA.	THIS DOCUMENT CONTROLLED BY CHANGE CONTROL SYSTEM 3 ENGINEERING PROCEDURE SNS-ENG-6001	SECTION AND DETAIL KEY DRAWING ON WHICH SECTION OR DETAIL IS SHOWN OR TAKEN
REVISION OR ISSUE PURPOSE	DESCRIPTION	DATE
1	CERTIFIED FOR CONSTRUCTION - 10/26/01	10/26/01

REVISION	DATE	BY
1	10/26/01	WJS
2	11/2/01	WJS

PROJECT NAME:	SPALLATION NEUTRON SOURCE	
DRAWING TITLE:	TARGET BUILDING ELECTRICAL AUXILIARY PLAN LEVEL 2, SECTOR 48	
REV.	DATE	BY
1	4/18/01	WJS
2	10/26/01	WJS
3	11/2/01	WJS
4		
5		
6		
100		