



1 2TU BUILDING FLOOR PLAN LEVEL 1
 E6.01.50 SCALE: 1/4" = 1'-0"

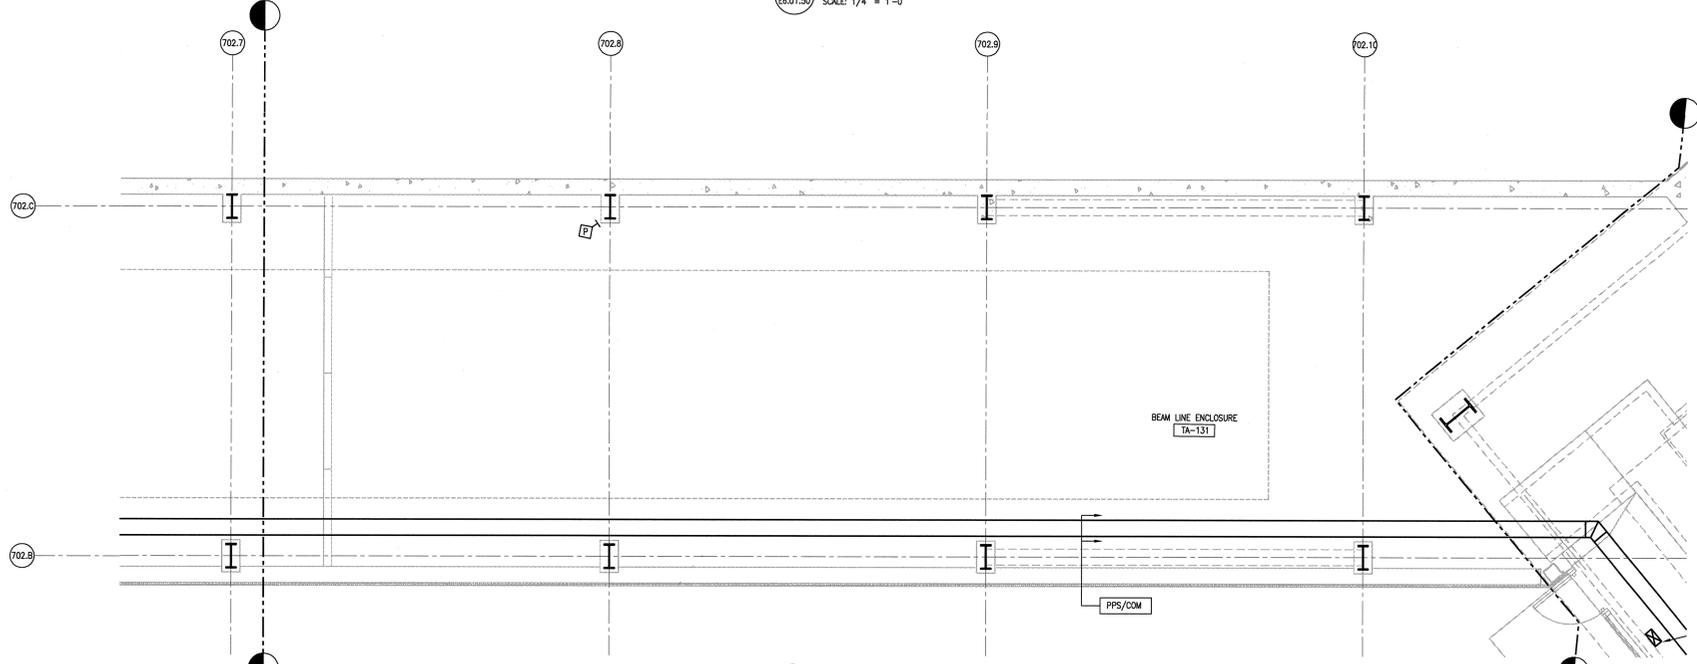

2 2TU BUILDING FLOOR PLAN LEVEL 1
 E6.01.50 SCALE: 1/4" = 1'-0"

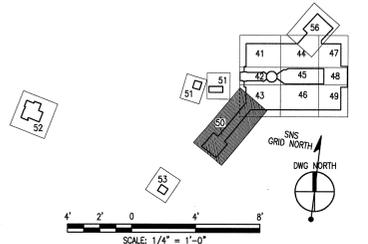

108030700-E8E-8702-A003

Knight Jacobs
 Knight Jacobs Joint Venture
 701 Scoboro Road, MS 9253
 Oak Ridge, TN 37830
 865-241-9433
 fax 865-241-3400

KNIGHT
 Knight Advanced Technology
 53 West Kentucky Street
 Clinton, TN 38011

UT-BATTELLE Oak Ridge National Laboratory
 managed for the DEPARTMENT OF ENERGY under
 U.S. GOVERNMENT contract DE-AC05-00OR22725
 UT-BATTELLE, LLC, a Oak Ridge, Tennessee

PROJECT NAME:
SPALLATION NEUTRON SOURCE

INSTRUMENT 2TU ENCLOSURE
ELECTRICAL COMMUNICATIONS PLAN
LEVEL 1, SECTOR 50

1	48	49	50	PLANT	BLDG	FL	SH.	OF	TYPE	CLASS
3	E	X	X	8	8702	1	1	1	P	U
51	52	53	WBS	REV	DATE	BY	CHK	APP	DATE	REV
NC	NA	53	1.8.3.7	E6.01.50	0					

DSN	H. EVANS	10/26/01
DRW	L. MAKOVSKY	10/26/01
CHK	V. STEFFEN	10/26/01
DEPT		
PE	<i>[Signature]</i>	11/18/01
PJ	<i>[Signature]</i>	11/18/01
REQ		
RPE		
REV.	0	10-26-01
DATE		
LITE	<i>[Signature]</i>	11/18/01
DATE		

REV	0	1	2	3	4	5	6	7	8	9	10	11	12	13	14	15	16	17	18	19	20	
DATE																						
DESCRIPTION																						
REVISION OR ISSUE PURPOSE																						

THIS DOCUMENT CONTROLLED BY
 CHANGE CONTROL SYSTEM 3
 ENGINEERING PROCEDURE SNS-ENG-0001

SECTION AND DETAIL KEY

NO REPRESENTATION OR WARRANTY, EXPRESSED OR IMPLIED, IS MADE AS TO THE ACCURACY, COMPLETENESS OR USEFULNESS OF THE INFORMATION OR STATEMENTS CONTAINED IN THESE DRAWINGS, OR THAT THE USE OR DISCLOSURE OF ANY INFORMATION, APPLICABLE METHOD, OR PROCESS DISCLOSED IN THESE DRAWINGS MAY NOT INFRINGE PRIVATE RIGHTS OF OTHERS. NO LIABILITY IS ASSUMED WITH RESPECT TO THE USE OF, OR FOR DAMAGES RESULTING FROM THE USE OF ANY INFORMATION, APPLICABLE METHOD, OR PROCESS DISCLOSED IN THESE DRAWINGS. DRAWINGS MADE AVAILABLE FOR INFORMATION TO BIDDERS ARE NOT TO BE USED FOR OTHER PURPOSES AND ARE TO BE RETURNED UPON REQUEST OF THE FORWARDING CONTRACTOR.

AutoCAD

8

7

6

5

4

3

2

1

A

H

G

F

E

D

C