


GENERAL NOTES:

- SEE DRAWINGS E9.21.52 AND E9.21.53 FOR LIGHTING PANEL SCHEDULES.
- SEE DRAWINGS E9.30.01 AND E9.30.02 FOR FIXTURE SCHEDULES.


KEYED NOTES:

- N001 ALL NORMAL LIGHTING FIXTURES ON THIS DRAWING ARE CIRCUITED FROM PANEL ZL6A LOCATED IN ELECTRICAL ROOM 2-3-8B.
- N002 ALL EMERGENCY LIGHTING FIXTURES AND EXIT SIGNS ON THIS DRAWING ARE CIRCUITED FROM PANEL B15EA LOCATED IN ELECTRICAL ROOM B1-2-31. LIGHTING IN STAIR NO. 2 TO BE CIRCUITED FROM PANEL B15EA IN ELECTRICAL ROOM B1-2-31.
- N003 ALL FIXTURES ARE MOUNTED 9'-5" A.F.F. UNLESS OTHERWISE NOTED.
- N004 CORRIDOR FIXTURES (W1) ARE MOUNTED 8'-0" A.F.F.
- N005 FIXTURES (SU) ARE MOUNTED ON TOP OF ENTRY VESTIBULE, TO ILLUMINATE THE BOTTOM OF ENTRY CANOPY.
- N006 FIXTURE (D) IS MOUNTED 1'-0" ABOVE DOOR TO ILLUMINATE STAIRCASE.
- N007 ELECTRICAL CONTRACTOR SHALL FURNISH AND INSTALL TWELVE (12) FIXTURE TYPE "SUA" REQUIRED IN AUDITORIUM MEZZANINE CONCRETE STEPS WITH ASSOCIATED CONDUIT. CONDUIT SHALL BE EMBEDDED AND EXTENDED OUT TO AN ACCESSIBLE AREA FOR FUTURE CONNECTION TO AUDITORIUM DIMMER PANEL LOCATED IN ELECTRICAL ROOM 1-1-4.

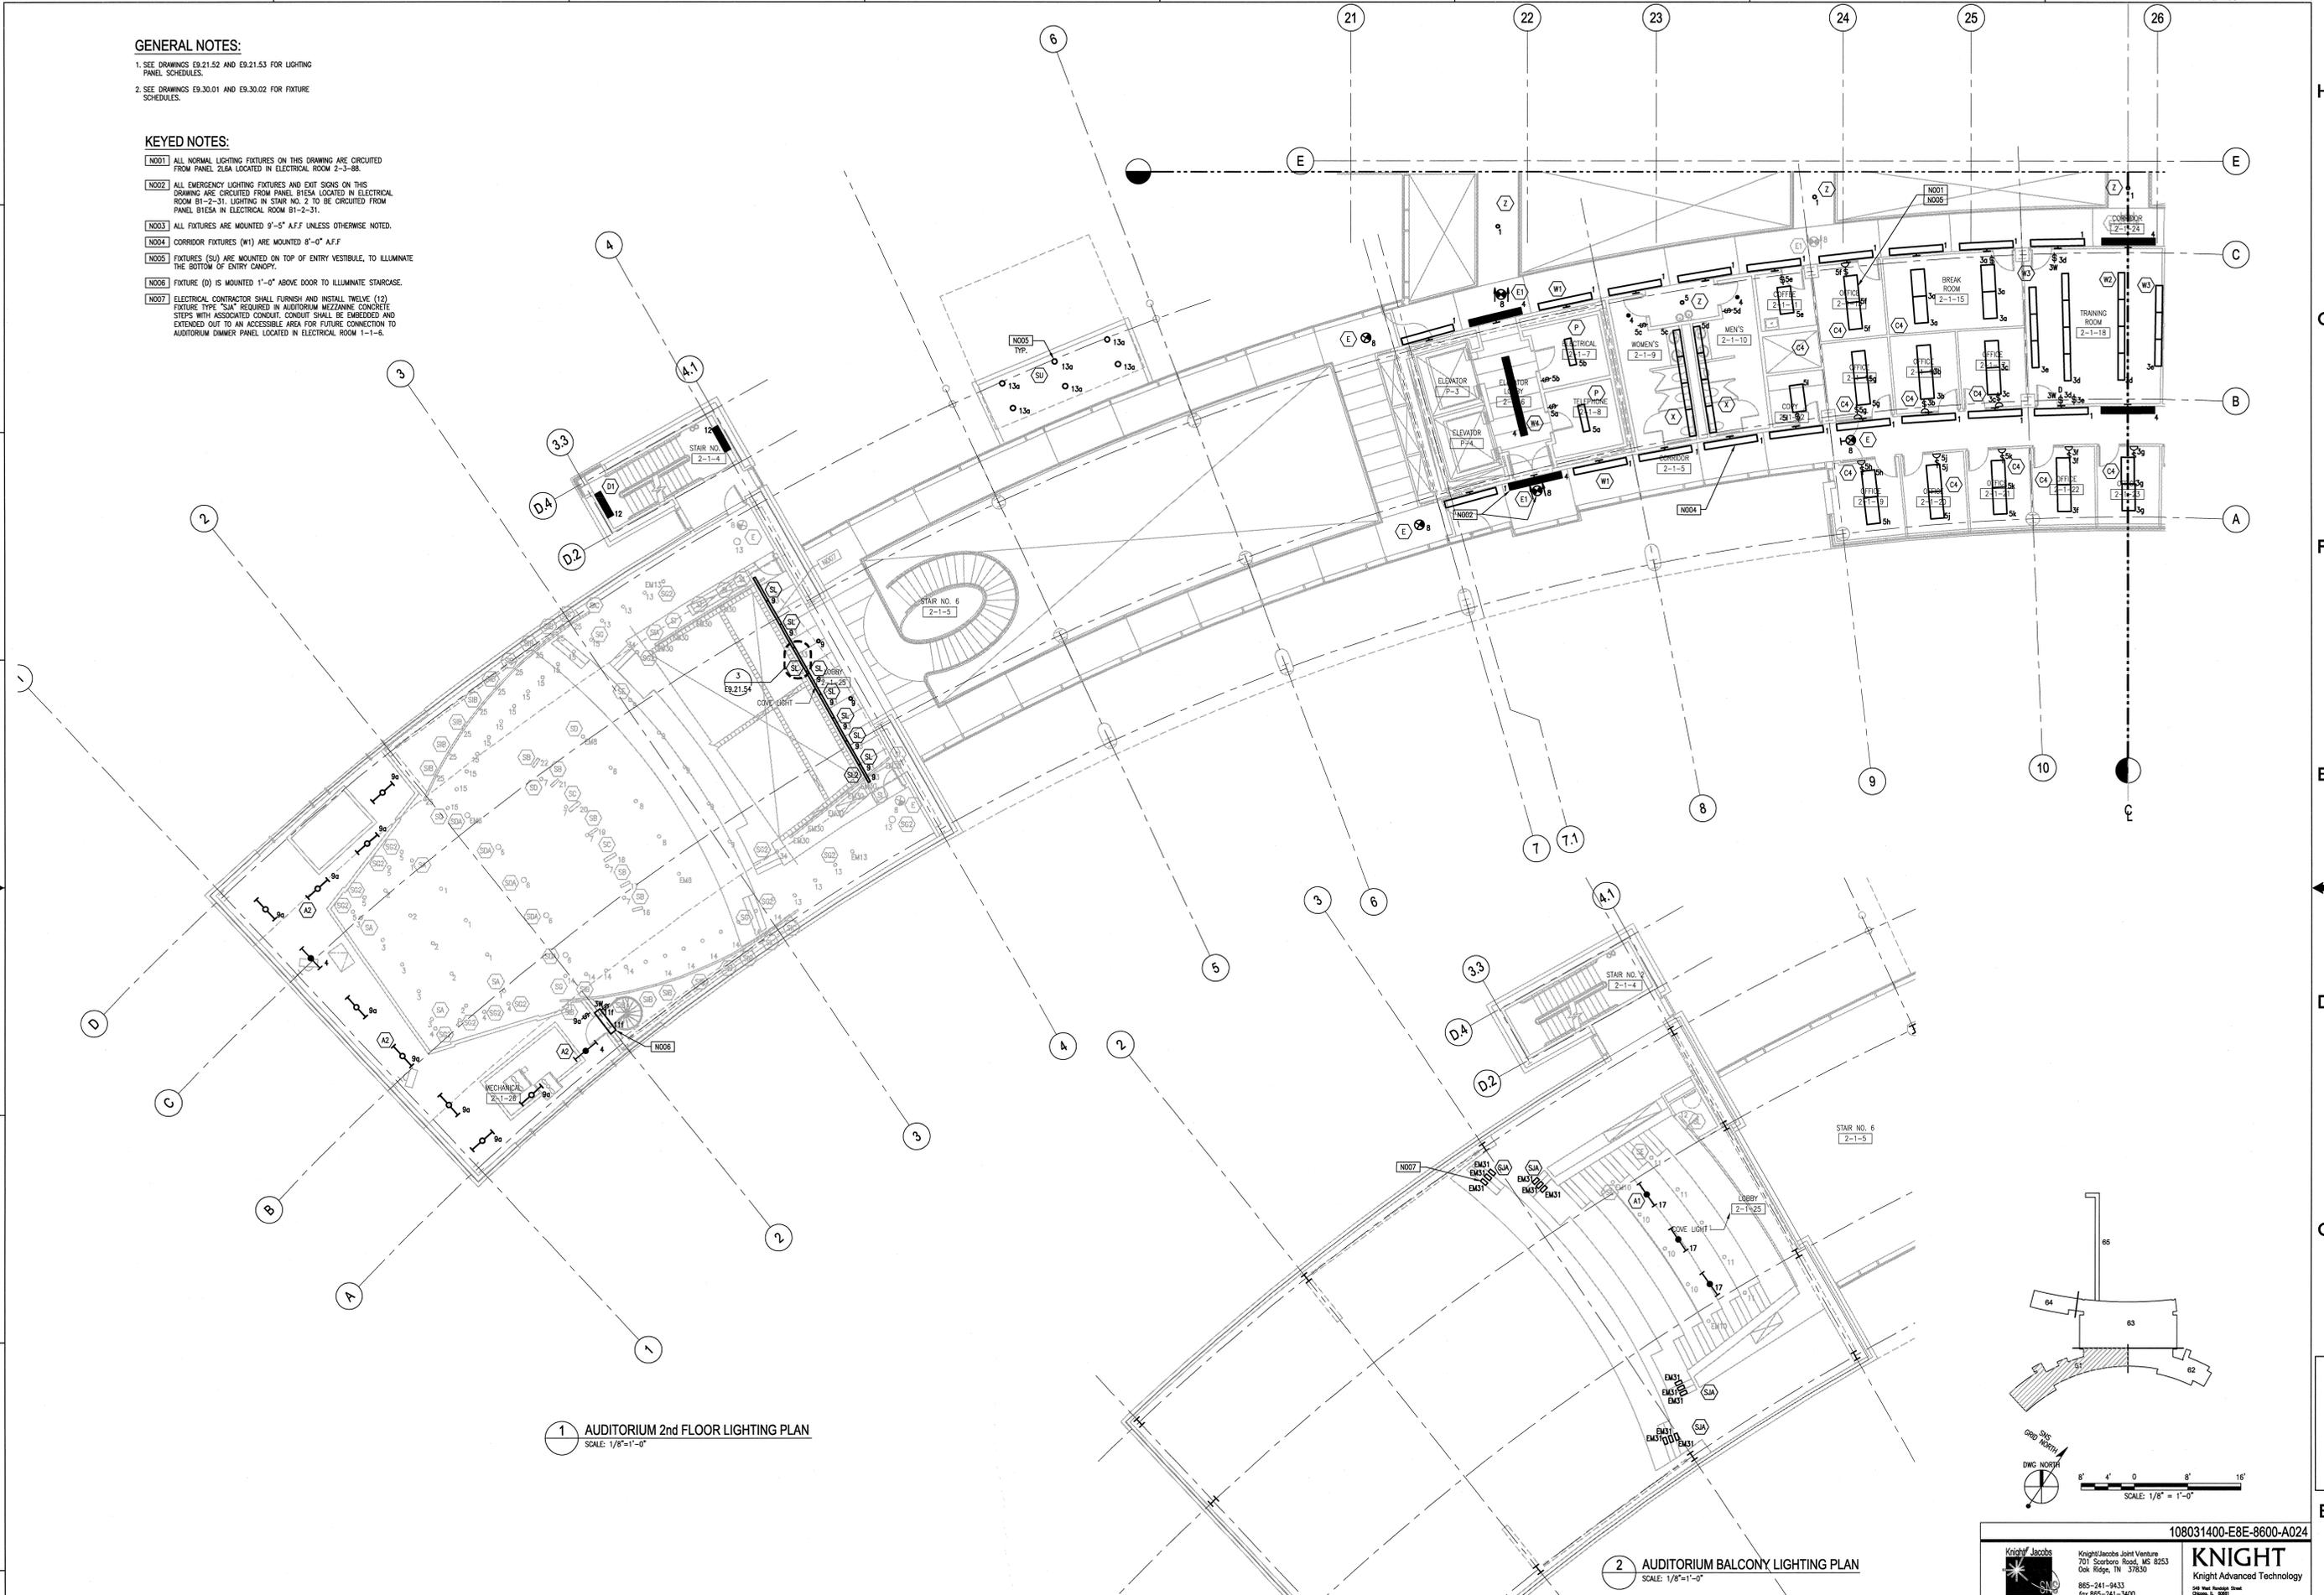

1 AUDITORIUM 2nd FLOOR LIGHTING PLAN
SCALE: 1/8"=1'-0"

2 AUDITORIUM BALCONY LIGHTING PLAN
SCALE: 1/8"=1'-0"

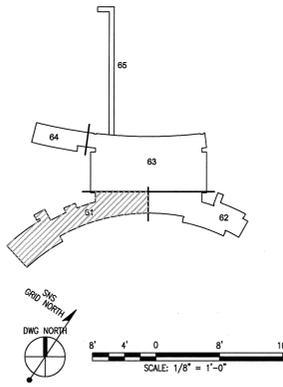

108031400-E8E-8600-A024

KNIGHT
Knight Advanced Technology
408 West Hubbard Street
Chicago, IL 60610

KNIGHT
Knight Jacobs Joint Venture
701 Scorsboro Road, MS 8253
Oak Ridge, TN 37830
865-241-9433
for 865-241-3400

Oak Ridge National Laboratory
managed for the DEPARTMENT OF ENERGY under
U.S. GOVERNMENT contract DE-AC05-00OR22725
© UT-BATTELLE, LLC • Oak Ridge, Tennessee

PROJECT NAME:
**SPALLATION NEUTRON SOURCE
CENTRAL LAB AND OFFICE BUILDING
ELECTRICAL LIGHTING PLAN
LEVEL 02, SECTOR 61**

1	48	49	50	PLANT	BLDG	FL	SH.	OF	TYPE	CLASS
3	E	X	X	8	8600		1	1	P	U
51	NC	52	NA	53	WBS					
					1.8.3.14				E3.02.61	1



DSN	T. WHITE	5/15/01
DRW	T. WHITE	5/15/01
CHK	K.SZOT	5/15/01
DEPT		
PE	C.L. GARREN	9/6/01
PJ	J. STELLERN	8/21/01
REQ		
REV		
LITB	J.R. LAWSON	9/25/01

REV	DATE	DESCRIPTION	DSN	CHK	DEPT	DATE	PE	DATE	PJ	DATE	REQ	DATE	UTB	DATE	RPE	RPE NO	DATE	ST	CV	EC	EE	EM	IE	M	PD	SE	AR	
1		CERTIFIED FOR CONSTRUCTION - 12/20/01																										
0		CERTIFIED FOR CONSTRUCTION - 5/15/01																										

NO REPRESENTATION OR WARRANTY, EXPRESSED OR IMPLIED, IS MADE AS TO THE ACCURACY, COMPLETENESS OR USEFULNESS OF THE INFORMATION OR STATEMENTS CONTAINED IN THESE DRAWINGS, OR THAT THE USE OR DISCLOSURE OF ANY INFORMATION, APPARATUS, METHOD, OR PROCESS DISCLOSED IN THESE DRAWINGS MAY NOT INFRINGE PATENT RIGHTS OF OTHERS. NO LIABILITY IS ASSUMED WITH RESPECT TO THE USE OF, OR FOR DAMAGES RESULTING FROM THE USE OF ANY INFORMATION, APPARATUS, METHOD, OR PROCESS DISCLOSED IN THESE DRAWINGS. DRAWINGS MADE AVAILABLE FOR INFORMATION TO BIDDERS ARE NOT TO BE USED FOR OTHER PURPOSES AND ARE TO BE RETURNED UPON REQUEST OF THE FURNISHING CONTRACTOR.

THIS DOCUMENT CONTROLLED BY
CHANGE CONTROL SYSTEM 4
ENGINEERING PROCEDURE SNS-ENG-0001

SECTION AND DETAIL KEY