
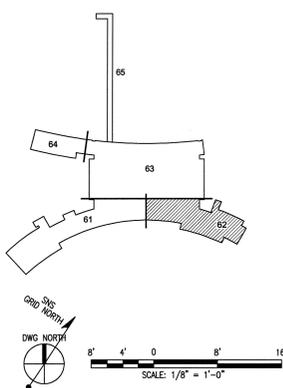


GENERAL NOTES:

- FOR ELECTRICAL SYMBOLS AND ABBREVIATIONS REFER TO DRAWING E.00.01
- CABLE TRAY FOR VOICE/DATA WIRING ONLY. MOUNT BOTTOM OF TRAY 1'-0" ABOVE FINISHED CEILING.
- PROVIDE SLEEVED OPENING FOR ALL TELEPHONE ROOM FLOOR PENETRATIONS. REFER TO DWG E8.20.40 FOR CONDUIT QTY AND SIZE AND DWG E8.10.47 DETAIL 5.

KEYNOTES:

- NO01** CENTER THE FLOOR MOUNT VOICE/DATA BOX WITHIN ROOM. (TYP)
- NO02** CONNECT P.A. SPEAKERS TO AMPLIFIER 4-PA1 LOCATED IN TELEPHONE ROOM 4-2-104.
- NO03** MOUNT J-BOX IN CEILING SPACE. (TYP)

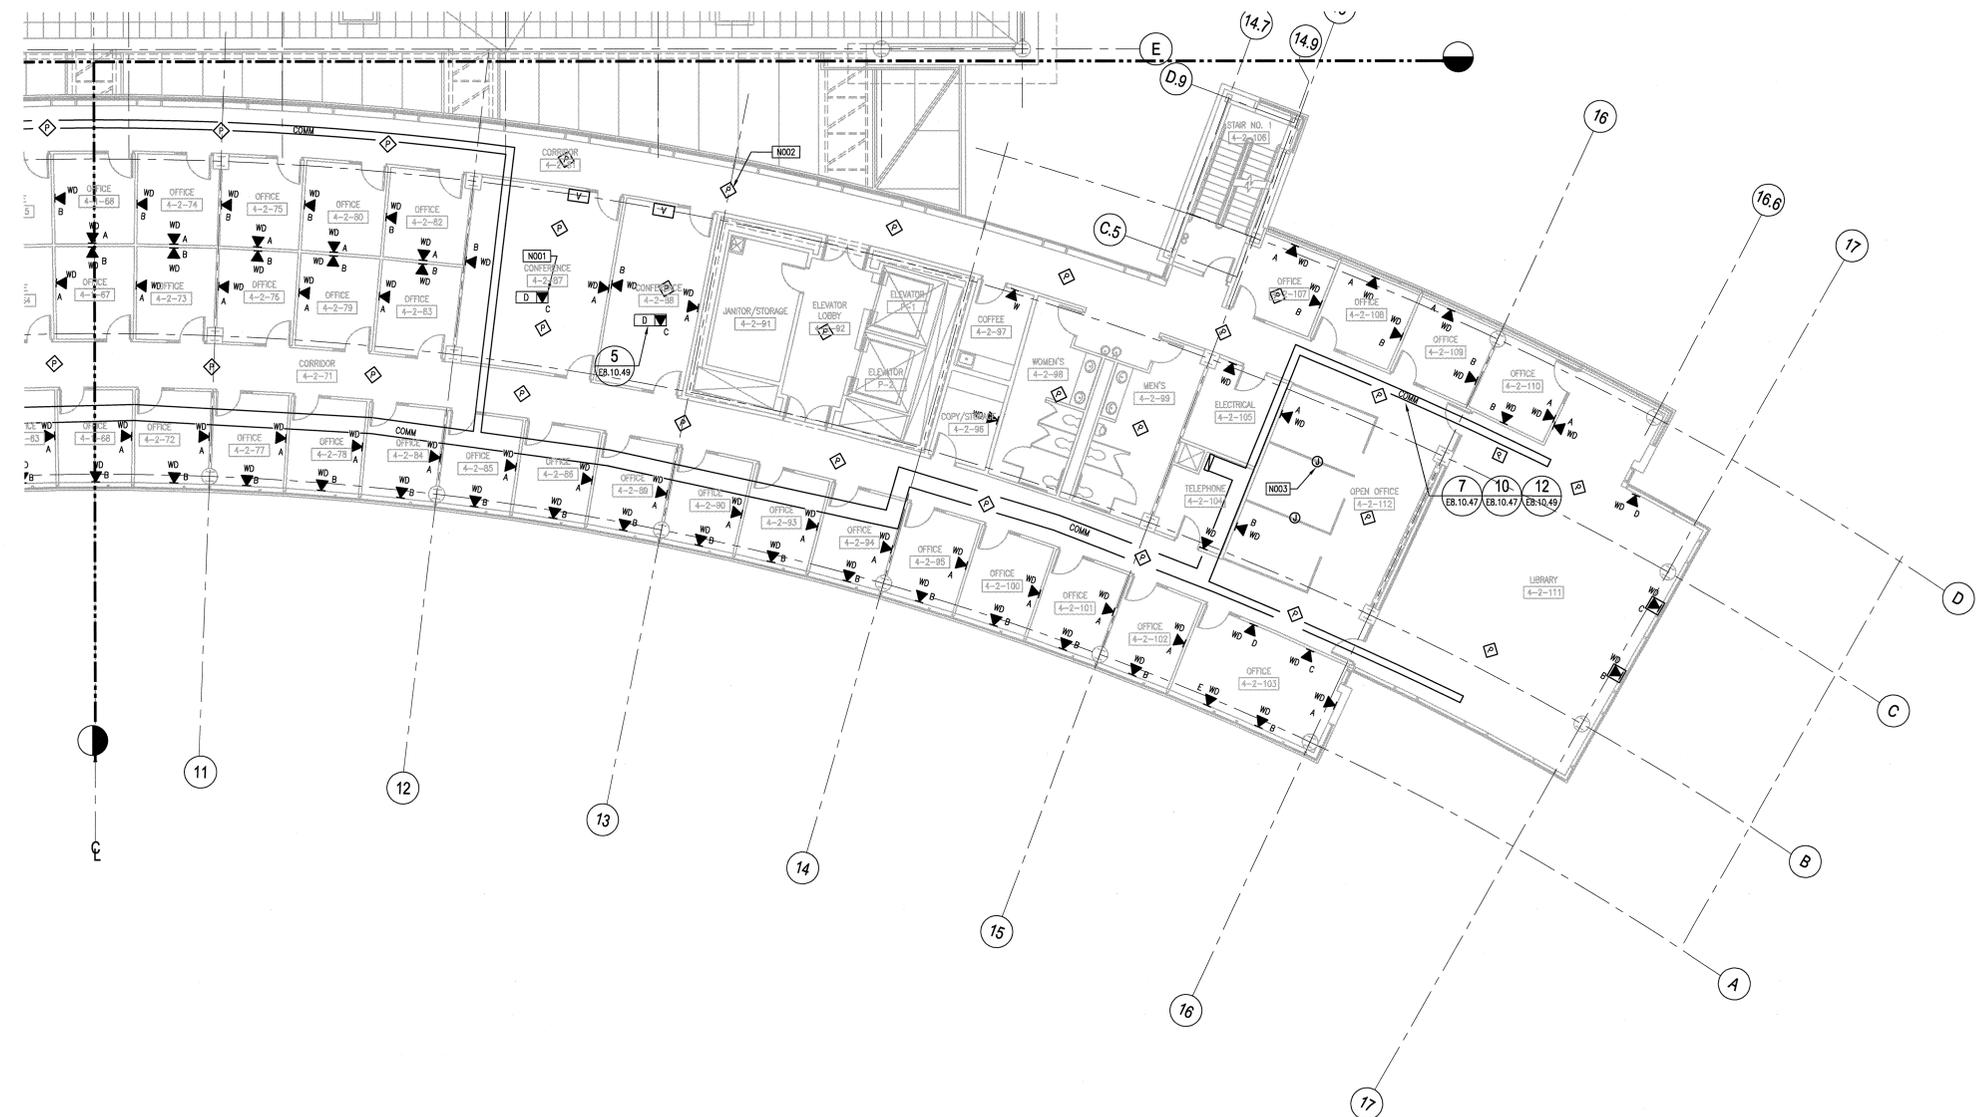

NO REPRESENTATION OR WARRANTY, EXPRESSED OR IMPLIED, IS MADE AS TO THE ACCURACY, COMPLETENESS OR USEFULNESS OF THE INFORMATION OR STATEMENTS CONTAINED IN THESE DRAWINGS, OR THAT THE USE OR DISCLOSURE OF ANY INFORMATION, APPARATUS, METHOD, OR PROCESS DISCLOSED IN THESE DRAWINGS MAY NOT INFRINGE PRIVATE RIGHTS OF OTHERS. NO LIABILITY IS ASSIGNED WITH RESPECT TO THE USE OF, OR FOR DAMAGES RESULTING FROM THE USE OF ANY INFORMATION, APPARATUS, METHOD, OR PROCESS DISCLOSED IN THESE DRAWINGS. DRAWINGS MADE AVAILABLE FOR INFORMATION TO BOOKS ARE NOT TO BE USED FOR OTHER PURPOSES AND ARE TO BE RETURNED UPON REQUEST OF THE FURNISHING CONTRACTOR.

SECTION AND DETAIL KEY

DRAWING ON WHICH SECTION OR DETAIL IS SHOWN OR TAKEN

THIS DOCUMENT CONTROLLED BY

CHANGE CONTROL SYSTEM 4

ENGINEERING PROCEDURE SNS-ENG-0001

REV	DATE	DESCRIPTION	DSN	CHK	DEPT	DATE	REQ	DATE	UTB	DATE	RPE	RPE NO	DATE	ST	CV	EC	EE	EM	IE	M	PD	SE	AR	
1		CERTIFIED FOR CONSTRUCTION - 12/20/01	LP	VS		10/1/01																		
0		CERTIFIED FOR CONSTRUCTION - 05/15/2001	LP	VS		10/1/01																		

REV	DATE	DESCRIPTION	DSN	CHK	DEPT	DATE	REQ	DATE	UTB	DATE	RPE	RPE NO	DATE	ST	CV	EC	EE	EM	IE	M	PD	SE	AR	
1	12-17-01																							

108031400-E8E-8600-A093

KNIGHT
 Knight Advanced Technology
 4715 Oak Ridge, TN 37830
 865-241-9433
 Fax 865-241-3400

UT-BATTELLE
 Oak Ridge National Laboratory
 managed for the DEPARTMENT OF ENERGY under
 U.S. GOVERNMENT CONTRACT DE-AC05-00OR22725
 OF BATTELLE, LLC, a Oak Ridge, Tennessee

PROJECT NAME:
**SPALLATION NEUTRON SOURCE
 CENTRAL LAB AND OFFICE BUILDING
 ELECTRICAL COMMUNICATIONS PLAN
 LEVEL 4, SECTOR 62**

1	48	49	50	51	52	53	54	55	56	57	58	59	60	61	62	63	64	65	66	67	68	69	70	71	72	73	74	75	76	77	78	79	80
3	E	X	X	X	X	X	X	X	X	X	X	X	X	X	X	X	X	X	X	X	X	X	X	X	X	X	X	X	X	X	X	X	X
1	48	49	50	51	52	53	54	55	56	57	58	59	60	61	62	63	64	65	66	67	68	69	70	71	72	73	74	75	76	77	78	79	80
3	E	X	X	X	X	X	X	X	X	X	X	X	X	X	X	X	X	X	X	X	X	X	X	X	X	X	X	X	X	X	X	X	X
1	48	49	50	51	52	53	54	55	56	57	58	59	60	61	62	63	64	65	66	67	68	69	70	71	72	73	74	75	76	77	78	79	80
3	E	X	X	X	X	X	X	X	X	X	X	X	X	X	X	X	X	X	X	X	X	X	X	X	X	X	X	X	X	X	X	X	X

UTB J.LAWSON 10/8/01

SCALE: 1/8" = 1'-0"

SECTION AND DETAIL KEY