
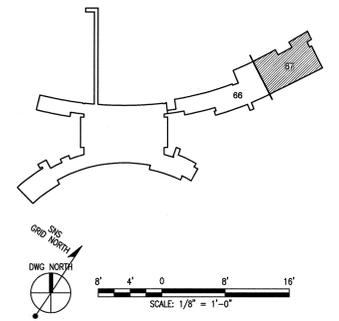


- KEYNOTES:**
- N001 OVERHEAD TEL/DATA CABLE TRAY, KEEP TO SOUTH SIDE OF CORRIDOR.
 - N002 THIS LENGTH OF CABLE TRAY NORTHWARD SHALL BE NONE-CONDUCTIVE TYPE.
 - N003 PROVIDE FIBER OPTIC DROPS FROM IT ROOM B1-4-52 IN ROOMS CN-B1-7-29, 33, 34, 35 AND 35. SEE DATA RISER, SHF EB.21.41
 - N004 GROUND BUS. SEE SHF E7.B1.67 FOR CONNECTION TO GROUND GRID. SEE DETAIL 12/EB.11.47.
 - N005 IN CR AREAS ALL POWER/COMM DEVICE LOCATIONS MUST BE COORDINATED WITH USER'S EQPT LOCATIONS THROUGH THE CM.

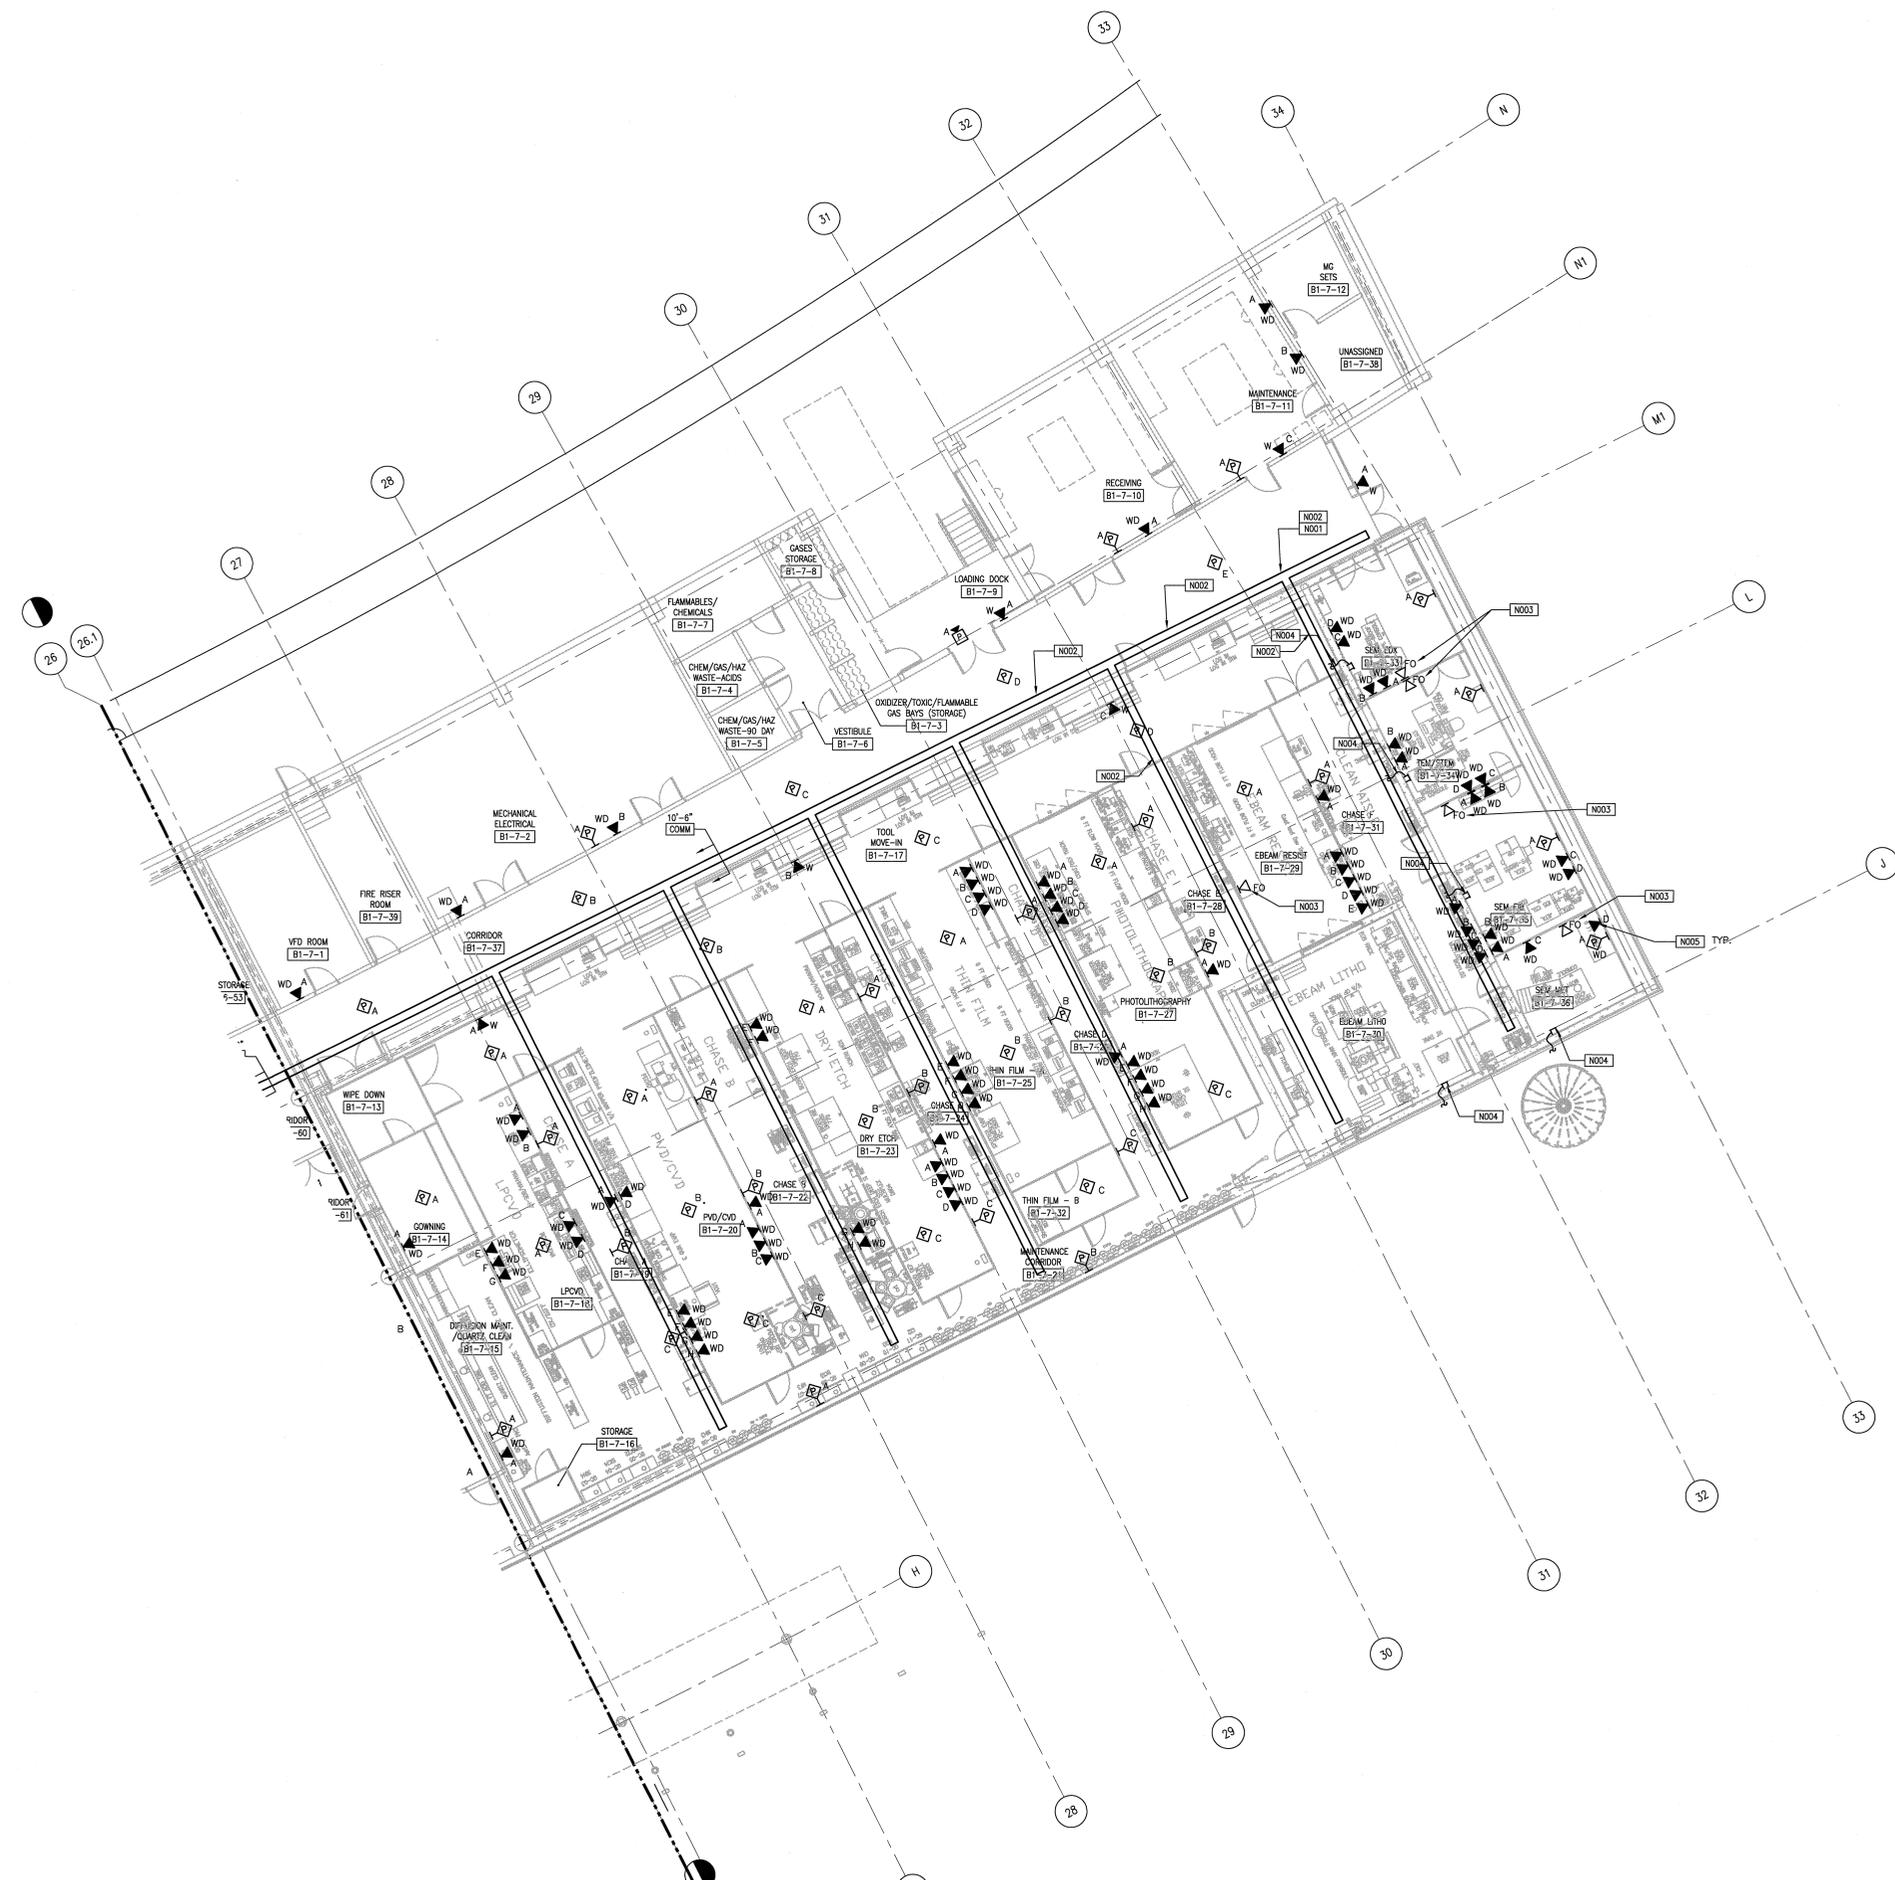

DRNL DRAWING NUMBER:
 Knight/Jacobs Joint Venture
 701 Scorsboro Road, MS 8253
 Oak Ridge, TN 37830
 865-241-9433
 fax 865-241-3400

M+W Zander U.S. Operations, Inc.
 649 West Randolph Street
 Chicago, IL 60661
 Telephone: (312) 677-3200
 Fax: (312) 677-3525

UT-BATTELLE
 Oak Ridge National Laboratory
 managed for the DEPARTMENT OF ENERGY under
 U.S. GOVERNMENT CONTRACT DE-AC05-00OR22725
 UT-BATTELLE, LLC, a Oak Ridge, Tennessee

PROJECT NAME:
**CENTER FOR NANOPHASE MATERIALS SCIENCES
 ELECTRICAL COMMUNICATIONS PLAN
 LEVEL B1 - SECTOR 67**


1	48	49	50	PLANT	BLDG	FL	SH.	OF	TYPE	CLASS
3	E	X	X	8	8610		1	1	P	U
51	52	53	A/E DRAWING NUMBER:		E6.B1.67					
NC	NA	NA			REV 0					

THIS DOCUMENT CONTROLLED BY
 CHANGE CONTROL SYSTEM
 ENGINEERING PROCEDURE

SECTION AND DETAIL KEY

REV	DATE	DESCRIPTION	DSN	CHK	DEPT	DATE	PE	DATE	DATE	REQ	DATE	UTB	DATE	RPE	RPE NO	DATE	ST	CV	EC	EE	EM	IE	M	PD	SE	AR
0		CERTIFIED FOR CONSTRUCTION 12/9/02																								

RPE	C. RUNG	12/09/02
DSN	L. MAKOVSKY	12/09/02
CHK	V. STEFFEN	12/09/02
PE	C. G. [Signature]	1/24/03
PJ	J. [Signature]	1/23/03
REQ	[Signature]	1/24/03

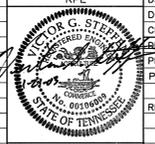

AutoCAD