
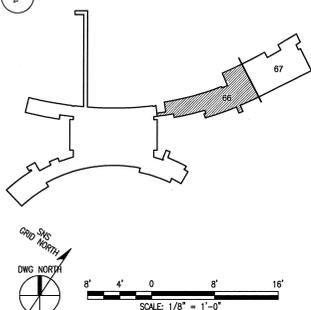


GENERAL NOTES

1. FOR VAV AND OTHER MECHANICAL EQUIPMENT LOCATION SEE DRAWING H4.01.66.
2. THE INFORMATION NEXT TO THIS THERMOSTAT LOCATION IS THE VAV NUMBER CONTROLLED BY THE THERMOSTAT.

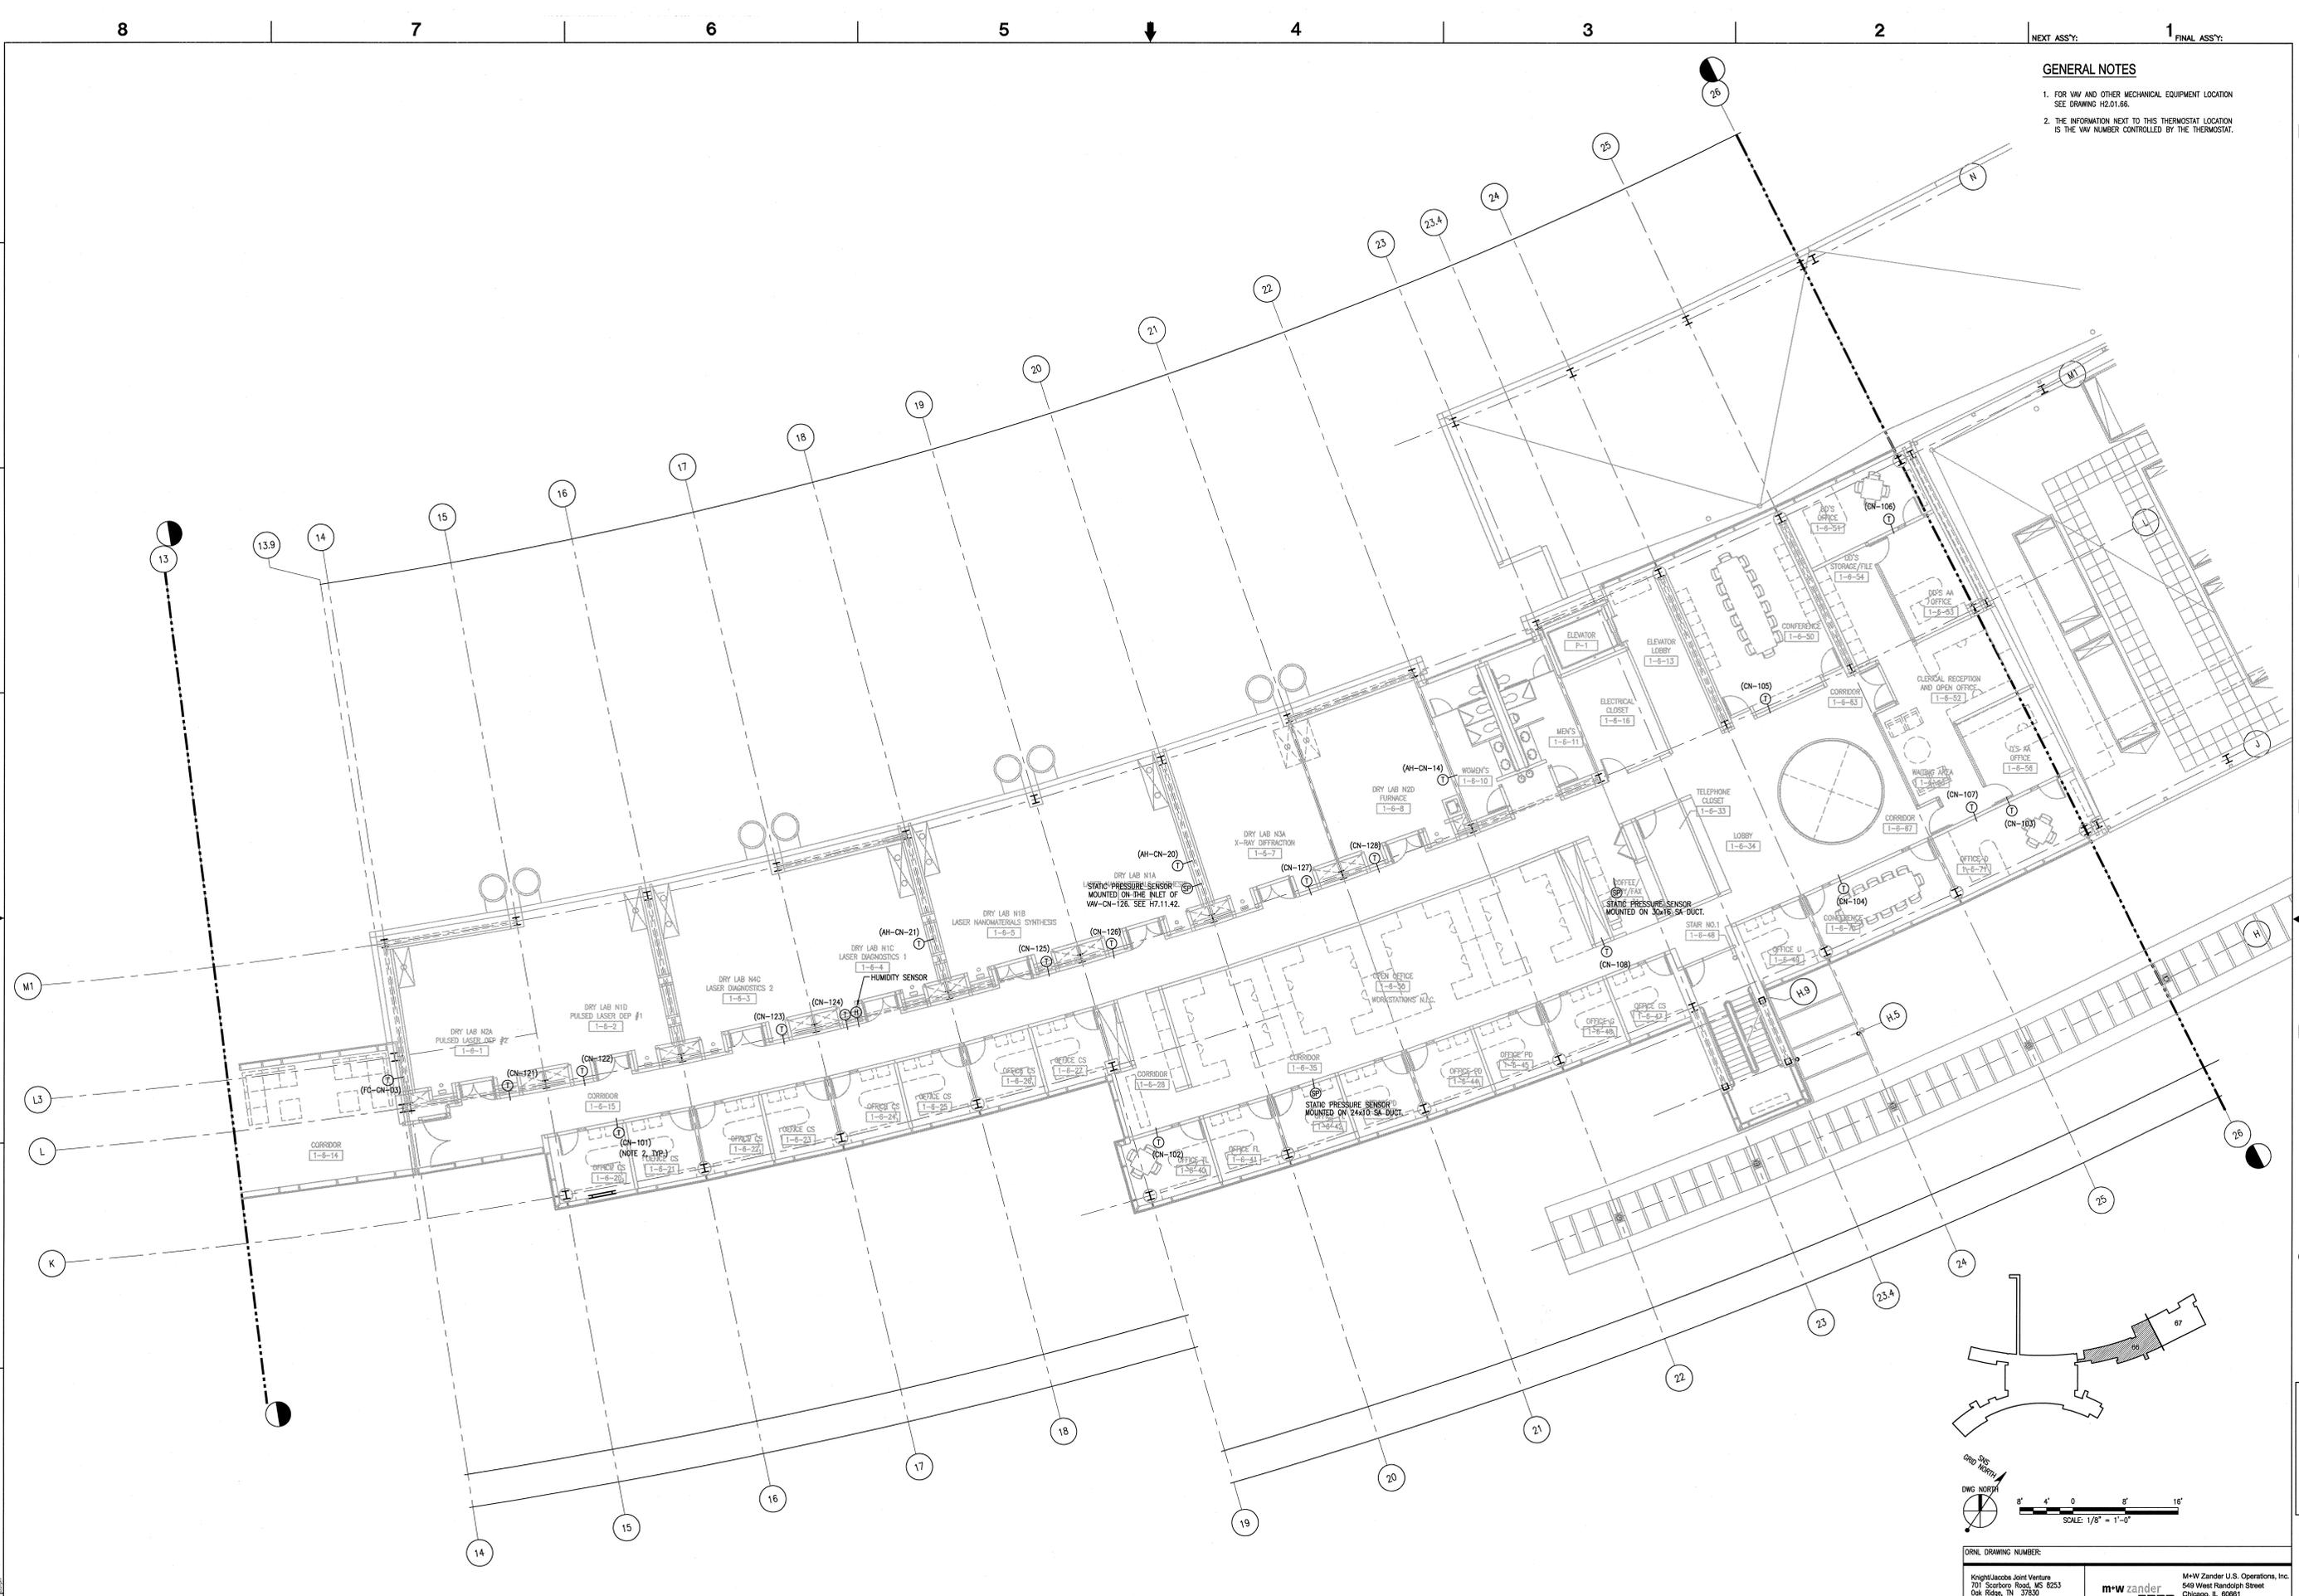

ORNL DRAWING NUMBER: Knight/Jacobus Joint Venture 701 Scarborough Road, MS 8253 Oak Ridge, TN 37830 Telephone: (615) 877-3200 Fax: (615) 877-3525		M+W Zander U.S. Operations, Inc. 549 West Randolph Street Chicago, IL 60661 Telephone: (312) 677-3200 Fax: (312) 677-3525								
UT-BATTELLE PROJECT NAME: CENTER FOR NANOPHASE MATERIALS SCIENCES HVAC FLOOR PLAN - INSTRUMENTS LOCATION LEVEL 1 - SECTOR 66										
1	48	49	50	PLANT	BLDG	FL	SH.	OF	TYPE	CLASS
3	H	X	X	8	8610	1	1	P	U	U
51	52	53	AVE DRAWING NUMBER:		H4.01.66		REV			
NC	NA	NA								

NO REPRESENTATION OR WARRANTY, EXPRESSED OR IMPLIED, IS MADE AS TO THE ACCURACY, COMPLETENESS OR USEFULNESS OF THE INFORMATION OR STATEMENTS CONTAINED IN THESE DRAWINGS, OR THAT THE USE OR DISCLOSURE OF ANY INFORMATION, APPARATUS, METHOD, OR PROCESS DISCLOSED IN THESE DRAWINGS MAY NOT INFRINGE PRIVATE RIGHTS OF OTHERS. NO LIABILITY IS ASSUMED WITH RESPECT TO THE USE OF, OR FOR DAMAGES RESULTING FROM THE USE OF ANY INFORMATION, APPARATUS, METHOD, OR PROCESS DISCLOSED IN THESE DRAWINGS. DRAWINGS MADE AVAILABLE FOR INFORMATION TO BIDDER ARE NOT TO BE USED FOR OTHER PURPOSES AND ARE TO BE RETURNED UPON REQUEST OF THE FORWARDING CONTRACTOR.		NUMBER OF SECTION OR DETAIL 	THIS DOCUMENT CONTROLLED BY CHANGE CONTROL SYSTEM ENGINEERING PROCEDURE
DRAWING ON WHICH SECTION OR DETAIL IS SHOWN OR TAKEN SECTION AND DETAIL KEY			

REV	DATE	DESCRIPTION	DSN	CHK	DEPT	PE	DATE	PU	DATE	REQ	DATE	UTB	DATE	RPE	RPE NO	DATE	ST	CV	EC	EE	EM	IE	M	PD	SE	AR	
0	-	CERTIFIED FOR CONSTRUCTION - 12/9/02	JG	BJW			12/9/02		12/9/02	105869	12/9/02	BZ	AW	BJW	AK	M	DM	-	BJW	-	TW						
REVISION APPROVALS SQUAD CHECK																											

RPE
 DSN
 DRW
 CHK
 DEPT
 P/E
 PU
 REQ
 DATE
 DRAWING APPROVALS