
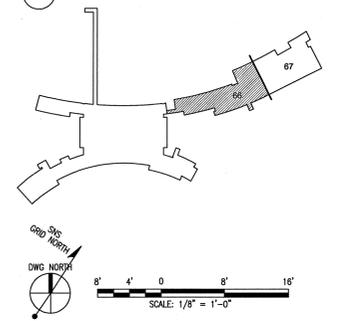


H
G
F
E
D
C
B
A

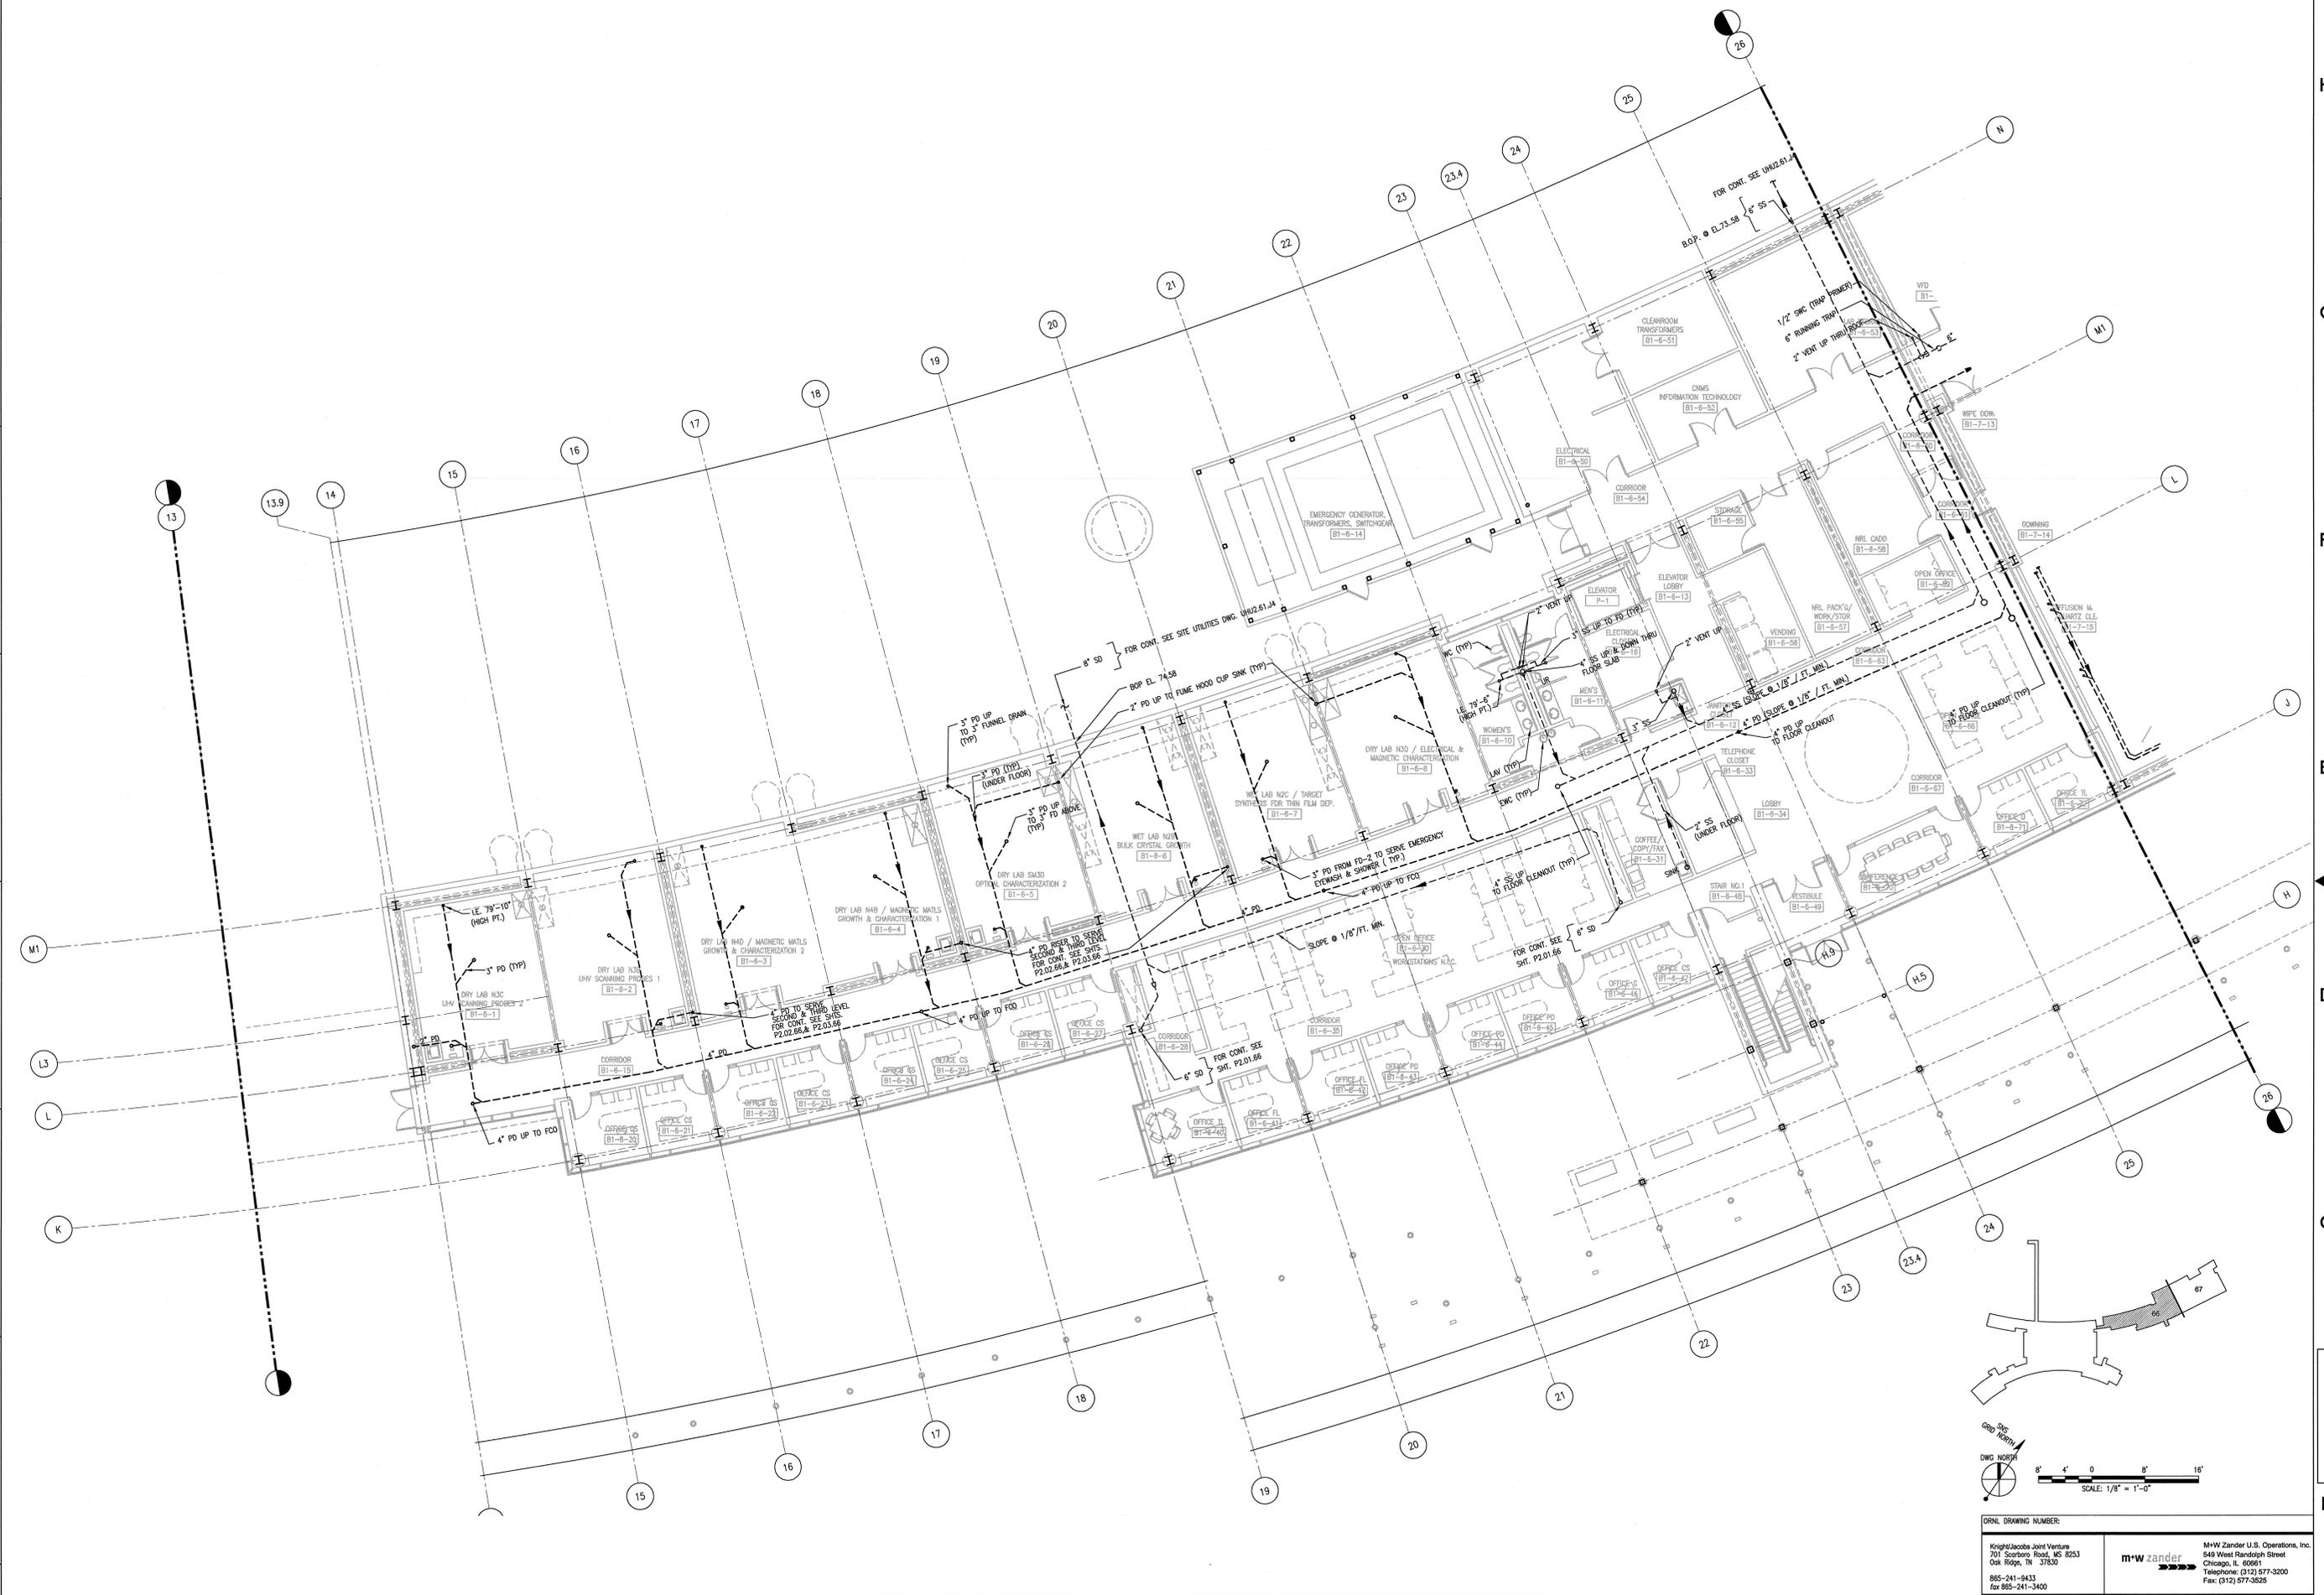

DRAWING NUMBER:
 Knight/Jacobs Joint Venture
 701 Scorsboro Road, MS 8253
 Oak Ridge, TN 37830
 Telephone: (615) 577-3200
 Fax: (615) 577-3525
 M+W Zander U.S. Operations, Inc.
 649 West Randolph Street
 Chicago, IL 60661
 Telephone: (312) 877-3200
 Fax: (312) 877-3525

NO REPRESENTATION OR WARRANTY, EXPRESSED OR IMPLIED, IS MADE AS TO THE ACCURACY, COMPLETENESS OR USEFULNESS OF THE INFORMATION OR STATEMENTS CONTAINED IN THESE DRAWINGS, OR THAT THE USE OR DISCLOSURE OF ANY INFORMATION, APPARATUS, METHOD, OR PROCESS DESCRIBED IN THESE DRAWINGS MAY NOT INFRINGE PRIVATE RIGHTS OF OTHERS. NO LIABILITY IS ASSUMED WITH RESPECT TO THE USE OF, OR FOR DAMAGES RESULTING FROM THE USE OF ANY INFORMATION, APPARATUS, METHOD, OR PROCESS DESCRIBED IN THESE DRAWINGS. DRAWINGS MADE AVAILABLE FOR INFORMATION TO BIDDERS ARE NOT TO BE USED FOR OTHER PURPOSES AND ARE TO BE RETURNED UPON REQUEST OF THE FORWARDING CONTRACTOR.

NUMBER OF SECTION OR DETAIL
 THIS DOCUMENT CONTROLLED BY
 CHANGE CONTROL SYSTEM
 ENGINEERING PROCEDURE
 SECTION AND DETAIL KEY

REV	DATE	DESCRIPTION	DSN	CHK	DEPT	DATE	FE	DATE	REQ	DATE	UTB	DATE	RPE	RPE NO	DATE	ST	CV	EC	EE	EM	IE	M	PD	SE	AR
0	-	CERTIFIED FOR CONSTRUCTION - 12/9/02	M	BMJ	DEPT	12/9/02								105869	12/9/02	BZ	AW	BS	AK	IM	DM	-	BMJ	-	TW

RPE
 DSN
 DRW
 CHK
 DEPT
 FE
 PJ
 REQ
 DATE 12/9/02
 UTB

UT-BATTELLE
 Oak Ridge National Laboratory
 managed for the DEPARTMENT OF ENERGY under
 U.S. GOVERNMENT contract DE-AC05-00OR22725
 PROJECT NAME:
CENTER FOR NANOPHASE MATERIALS SCIENCES
PIPING FLOOR PLAN
UNDERGROUND - SECTOR 66
 1 4B 49 50 PLANT BLDG FL SH. OF TYPE CLASS
 3 P X X 8 8610 1 1 P U
 51 52 53 A/E DRAWING NUMBER: P3.B1.66
 NC NA REV 0

AutocAD